 



(N) Sewer Manhole  
 (E) Sewer Manhole?  
 ASILOMAR BLVD.

= (E) Orange Burst  
 to be pipe burst  
 to 6" line  
 = plastic pipe to  
 use housing

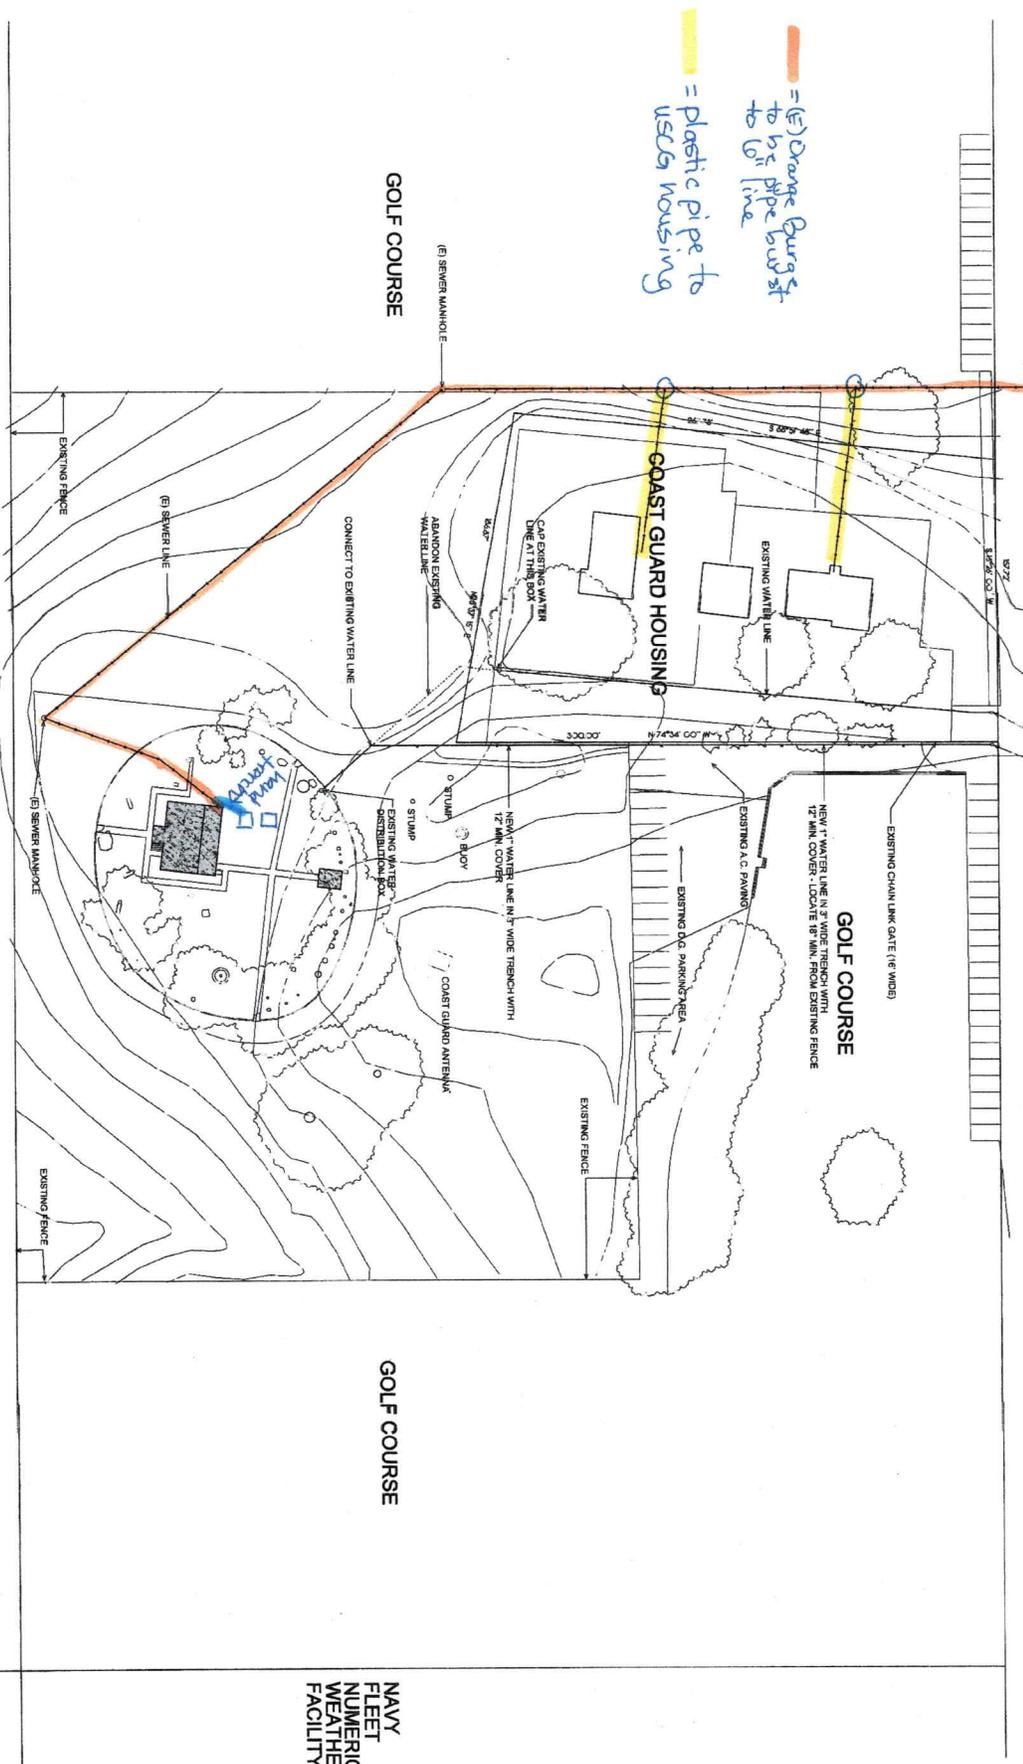

Point Pinos Lighthouse  
 OVERALL SITE PLAN  
 SCALE 1" = 30'-0"

SHEET  
 A1

NAVY  
 FLEET  
 NUMERICAL  
 WEATHER  
 FACILITY

Point Pinos Lighthouse Water Meter Split  
 CITY OF PACIFIC GROVE

PROJECT  
 DOUGLAS HOWE  
 ARCHITECT  
 20 MAIN STREET  
 SUITE 200  
 PACIFIC GROVE, CA 93950  
 PHONE: 708.442.9242  
 FAX: 708.442.9243  
 WWW.DHARCHITECT.COM